




NOTE: DIMENSIONS ON THESE DRAWINGS SHALL HAVE PRECEDENCE OVER SCALED DIMENSIONS. CONTRACTORS SHALL VERIFY AND BE RESPONSIBLE FOR ALL DIMENSIONS AND CONDITIONS ON THE JOB. THE DESIGNER MUST BE NOTIFIED IMMEDIATELY OF ANY VARIATIONS FROM THE DIMENSIONS AND CONDITIONS SHOWN BY THESE DRAWINGS.

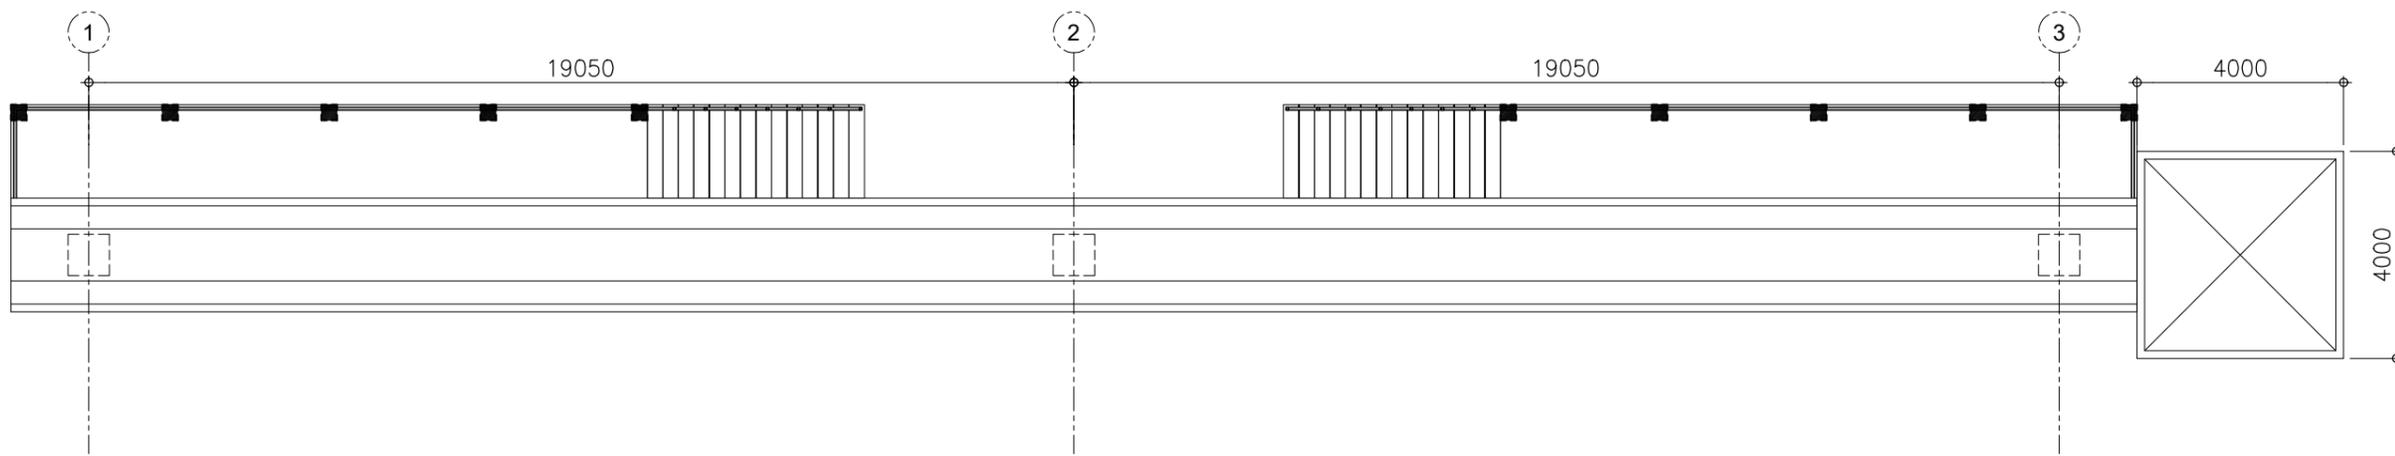

AUTOMATED GUIDEWAY TRANSIT SYSTEM  
**FLOOR PLAN**  
 SCALE 1:75mts

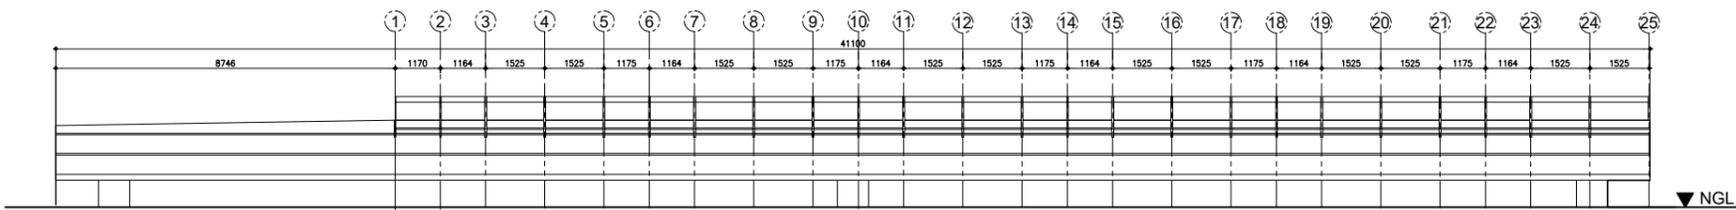

AUTOMATED GUIDEWAY TRANSIT SYSTEM  
**FRONT ELEVATION**  
 SCALE 1:100mts

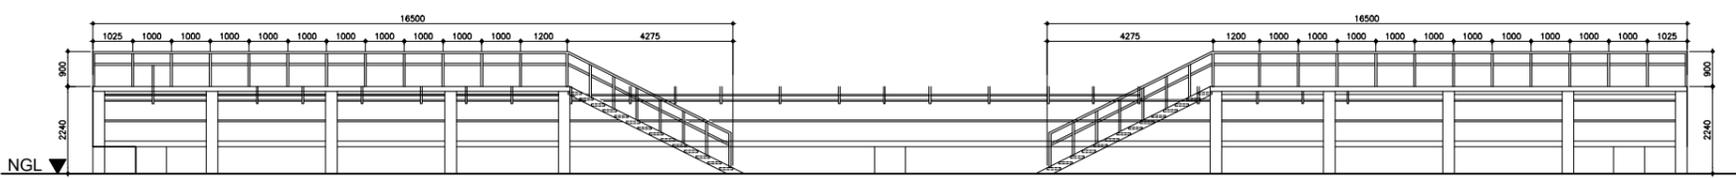

AUTOMATED GUIDEWAY TRANSIT SYSTEM  
**REAR ELEVATION**  
 SCALE 1:100mts

PROJECT TITLE  
**INSTALLATION OF AUTOMATIC  
 GUIDE-WAY TRANSIT (AGT) IN  
 BPSU MAIN CAMPUS**

LOCATION  
 BATAAN PENINSULA STATE UNIVERSITY (MAIN  
 CAMPUS), BALANGA CITY, BATAAN

STRUCTURAL ENGINEER  
 REG. NO.:  
 PIR. NO.:  
 PLACE:  
 TIN NO.:

MASTER PLUMBER/SANITARY ENGINEER  
 REG. NO.:  
 PIR. NO.:  
 PLACE:  
 TIN NO.:

PROFESSIONAL ELECTRICAL ENGINEER  
 REG. NO.:  
 PIR. NO.:  
 PLACE:  
 TIN NO.:

PROFESSIONAL MECHANICAL ENGINEER  
 REG. NO.:  
 PIR. NO.:  
 PLACE:  
 TIN NO.:

**REVISION**

| NO. | DESCRIPTION | DATE |
|-----|-------------|------|
| 1   |             |      |
| 2   |             |      |

PREPARED BY:  
  
**AR. ROXETTE S. UMEREZ**  
 ARCHITECT 1, BPSU TWG  
 REG. NO.:  
 PIR. NO.:  
 PLACE:  
 TIN NO.:

REVIEWED BY:  
  
**JASON ANTHONY BANZON**  
 CAMPUS DIRECTOR  
 REG. NO.:  
 PIR. NO.:  
 PLACE:  
 TIN NO.:

NOTED BY:  
  
**ENGR. ALFREDO D. VALENTOS**  
 DIRECTOR OF PPES  
 REG. NO.:  
 PIR. NO.:  
 PLACE:  
 TIN NO.:

RECOMMENDED BY:  
  
**DR. EDMUNDO C. TUNGOL**  
 VICE PRESIDENT ADMIN. & FINANCE  
 REG. NO.:  
 PIR. NO.:  
 PLACE:  
 TIN NO.:

APPROVED BY:  
  
**DR. GREGORIO J. RODIS**  
 UNIVERSITY PRESIDENT  
 REG. NO.:  
 PIR. NO.:  
 PLACE:  
 TIN NO.:

REPUBLIC ACT 9266.  
 NOTE: THIS DRAWING, AS AN INSTRUMENT OF SERVICE  
 IS THE PROPERTY OF : BATAAN PENINSULA STATE  
 UNIVERSITY AND AS SUCH MUST NOT BE  
 REPRODUCED OR COPIED IN PART OR IN WHOLE  
 WITHOUT THEIR PERMISSION ALL DRAWINGS ARE  
 TO BE RETURNED WHEN NO LONGER IN USE.

SHEET CONTENT: SHEET NUMBER:

S5



**BATAAN PENINSULA STATE UNIVERSITY**  
 TECHNICAL WORKING GROUP FOR INFRASTRUCTURE  
 CAPITOL COMPOUND, BRGY. TENEJERO, CITY OF BALANGA, BATAAN,  
 E-MAIL: bpsu.tech@bpsu.edu.ph / bpsuagc2017@gmail.com  
 TELEPHONE NO. : (047) 237-15-98